

PRINTS	DATE	ISSUED TO	REMARKS
REVISION	DATE	DESCRIPTION	BY
R0	29.11.2017	FOR APPROVAL	NIKHIL TYAC
R1	02.01.2018	FOR APPROVAL	NIKHIL TYAC
R2	31.02.2018	FOR APPROVAL	NIKHIL TYAC
R3	04.10.2019	FOR APPROVAL	BUNTY
	0.000		

ASSOCIATE ARCHITECTS-

DESIGN ASSOCIATES INC.

A - 163, Sector - 136, Noida - Greater Noida Expressway, Noida - 201301 Email: sachin.agarwal@designassociates.in

MECHANICAL CONSULTANT-

ARK CONSULTANT, NEW DELHI

ELECTRICAL CONSULTANT-ARK CONSULTANT, NEW DELHI

PLUMBING CONSULTANT-

ARK CONSULTANT, NEW DELHI

STRUCTURE CONSULTANT-

CE CON ENGG., NEW DELHI

PROJECT-

COMMERCIAL COMPLEX AT POLO MARKET SHILLONG

DRAWING TITLE-


GROUND FLOOR PLAN LV CABLE TRAY LAYOUT

DRAWING PURPOSE-

FOR TE	NDER PURPO	OSES ONLY
JOB NO	DWG. REF. NO	DATE-
		29.11.2017
SCALE-	REVISION-	DATE OF ISSUE-
1:150	R0	04.10.2019
DWG. NO	EL/SP-103	



	SHEET SIZE-	SHEET NO-
\	A1	
	DRAWN BY-	CHECKED BY-
	BUNTY	PANKAJ

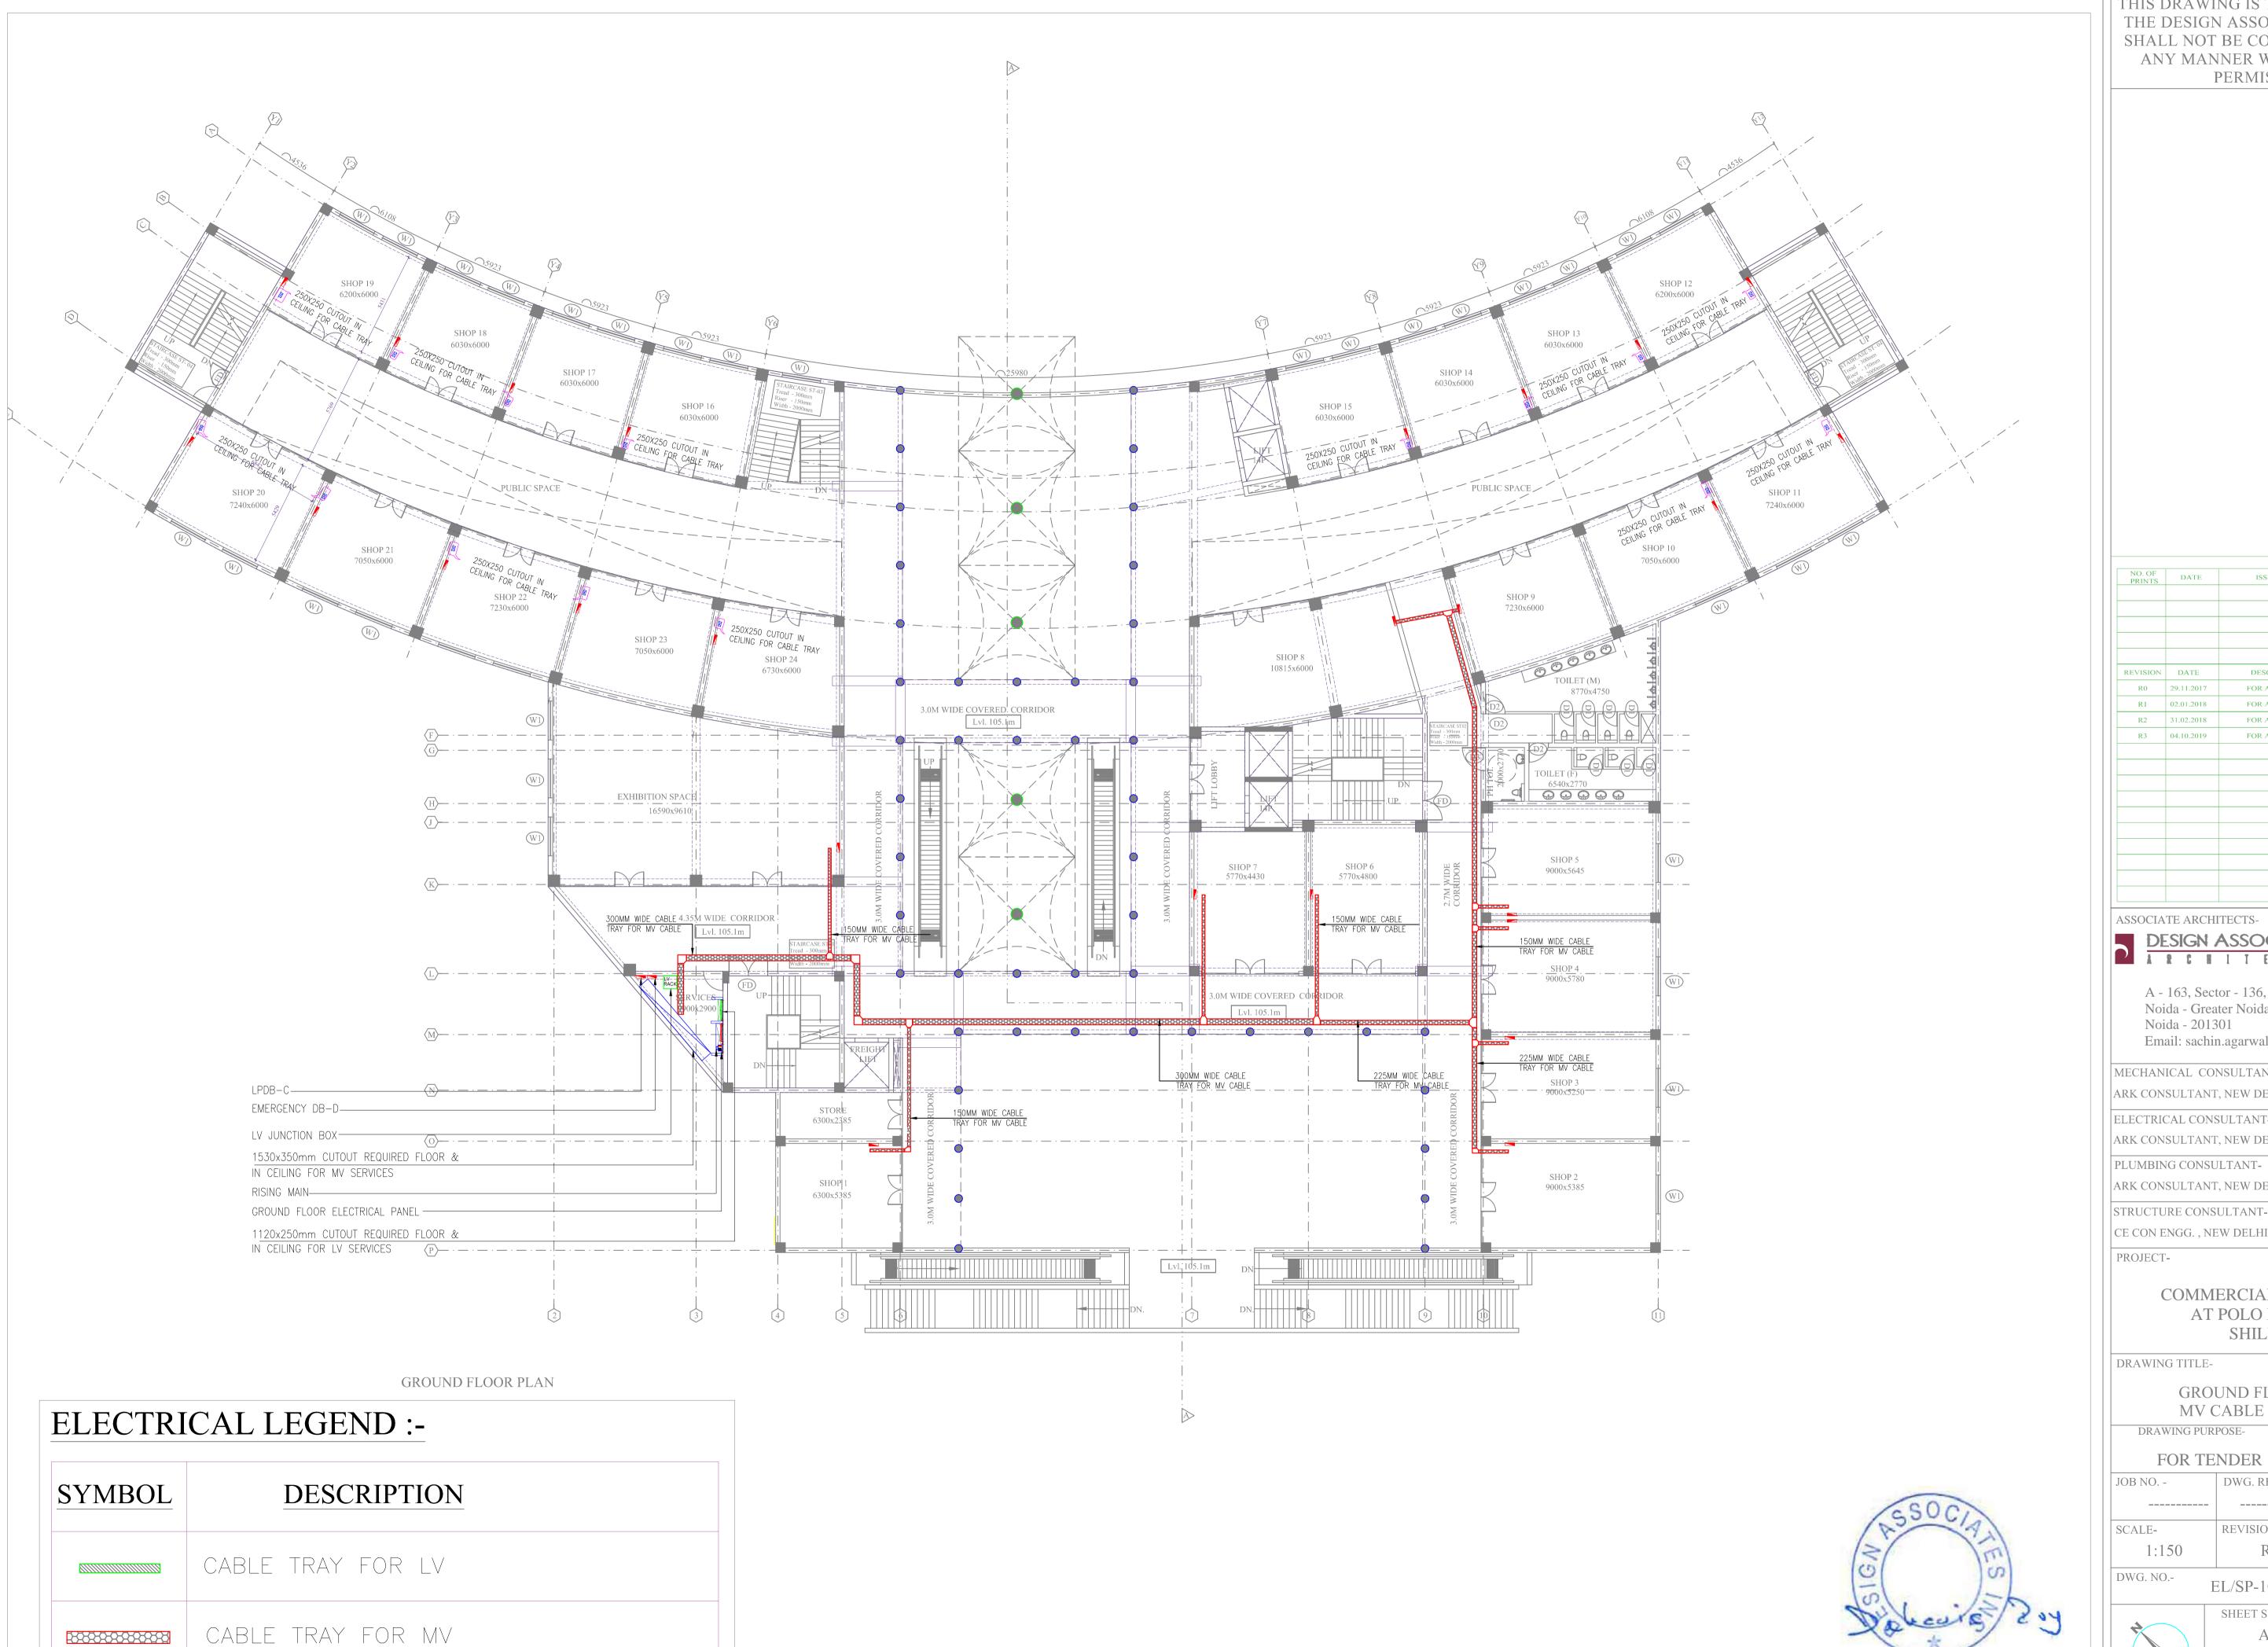

PRINTS	DATE	ISSUED TO	REMARKS
REVISION	DATE	DESCRIPTION	BY
R0	29.11.2017	FOR APPROVAL	NIKHIL TYAC
R1	02.01.2018	FOR APPROVAL	NIKHIL TYAC
R2	31.02.2018	FOR APPROVAL	NIKHIL TYAC
R3	04.10.2019	FOR APPROVAL	BUNTY

ASSOCIATE ARCHITECTS-

DESIGN ASSOCIATES INC.

A - 163, Sector - 136, Noida - Greater Noida Expressway, Noida - 201301 Email: sachin.agarwal@designassociates.in

MECHANICAL CONSULTANT-

ARK CONSULTANT, NEW DELHI

ELECTRICAL CONSULTANT-

ARK CONSULTANT, NEW DELHI

ARK CONSULTANT, NEW DELHI

STRUCTURE CONSULTANT-

CE CON ENGG., NEW DELHI

PROJECT-

COMMERCIAL COMPLEX AT POLO MARKET SHILLONG

DRAWING TITLE-

GROUND FLOOR PLAN MV CABLE TRAY LAYOUT

DRAWING PURPOSE-

JOB NO	DWG. REF. NO	DATE-
		29.11.2017
SCALE-	REVISION-	DATE OF ISSUE-
1:150	R0	04.10.2019
DWG. NO		

EL/SP-102



SHEET SIZE-	SHEET NO-
A1	
DRAWN BY-	CHECKED BY-
BUNTY	PANKAJ

DISTRIBUT	TION BOARD:-LPDB-C		6 WAY TPN	L	OC:-GROUND	FLOOR	
CKT.	WIRE SIZE IN	SP MCB'S	LOCATION	NO. OF POINTS		LOAD IN WATTS	
NO.	SQ. MM."CU"	IN AMPS			R PAASE	Y PAASE	B PAASE
C1	2x1.5+1x1.5(E)	10	SERVICES & CORRIDOR	10	210		
C2	2x1.5+1x1.5(E)	10	CORRIDOR	09	180		
С3	2x1.5+1x1.5(E)	10	CORRIDOR	06		120	
C4	2x1.5+1x1.5(E)	10	CORRIDOR	05		100	
C5	2x1.5+1x1.5(E)	10	CORRIDOR	05			100
C6	2x1.5+1x1.5(E)	10	CORRIDOR	08			160
C7	2x1.5+1x1.5(E)	10	LIFT LOBBY & CORRIDOR	09	180		
C8	2x1.5+1x1.5(E)	10	CORRIDOR	07	140		
C9	2x1.5+1x1.5(E)	10	CORRIDOR	05		100	
C10	2x1.5+1x1.5(E)	10	CORRIDOR	06		120	
C11	2x1.5+1x1.5(E)	10	TOILET (M)	11			220
C12	2x1.5+1x1.5(E)	10	TOILET (F)	11			220
C13	2x1.5+1x1.5(E)	10	CORRIDOR	07		140	
C14	2x1.5+1x1.5(E)	10	CORRIDOR	06		120	
C15			SPARE				
C16			SPARE				
C17			SPARE				
C18			SPARE				
FROM:		N MCB & 3 NOS 2 1.5 Cu.WIRE IN 32	25 AMPS DP ELCB (30mA) RMMØ CONDUIT	TOTAL GRAND TO	710W TAL	2.11 KW	700W

DISTRIBUT	TION BOARD:-UPSDB-D		8 WAY SPN	LOC:-GROUND FLOOR	
CKT.	WIRE SIZE IN	SP MCB'S	LOCATION	NO. (POINT	
NO.	SQ. MM."CU"	IN AMPS			PAASE
D1	2x1.5+1x1.5(E)	10	CORRIDOR	09	180
D2	2x1.5+1x1.5(E)	10	LIFT LOBBY & CORRIDOR	12	260
D3	2x1.5+1x1.5(E)	10	CORRIDOR	04	80
D4	2x1.5+1x1.5(E)	10	CORRIDOR	06	600
D5	2x1.5+1x1.5(E)	10	CORRIDOR	03	300
D6			SPARE		
D7			SPARE		
D8			SPARE		
FROM:	INCOMING: 25 AMP	DP MCB WITH 25	AMP DP RCCB (30mA)	TOTAL	1420W
	2x2.5+	2x1.5 Cu.WIRE IN	32MMø CONDUIT	GR.TOI	1.42KW



ELECTRICAL	LEGEND :
LLLCINICAL	LEGEND.

SYMBOL	DESCRIPTION
 >	SWITCH BOARD
 ⊳>	TWO WAY SWITCH BOARD
þ»	EM-TWO WAY SWITCH BOARD
*	(1x18WATT) LED LIGHT
€ E	(1x18WATT) LED EMERGENCY LIGHT
(4)	CEILING FAN
	(1x15W) MIRROR LIGHT (LED)
H.	BRACKET LIGHT
>	1x20W BULK HEAD LIGHT
$\stackrel{+}{\triangle}$	6A SWITCH SOCKET
<u></u>	6/16A 5PIN SWITCH SOCKET
> ••	CCTV
$\stackrel{\pm}{\triangle}$	6A SOCKET FOR CCTV
	LV JUNCTION BOX
	DISTRIBUTION BOARD
	25MMØ CONDUIT FOR LIGHT
	25MMØ CONDUIT FOR EMERGENCY
	25MMØ CONDUIT FOR POWER
	25MMØ CONDUIT FOR UPS
	25MMØ CONDUIT FOR LV

ATE 1.2017	DESCRIPTION FOR APPROVAL	BY NIKHIL TYAGI
	FOR APPROVAL	NIKHII TYAGI
		111111111111111111111111111111111111111
1.2018	FOR APPROVAL	NIKHIL TYAGI
1.2018	FOR APPROVAL	NIKHIL TYAGI
5.2018	FOR APPROVAL	NIKHIL TYAGI
0.2018	FOR APPROVAL	BUNTY
	5.2018	05.2018 FOR APPROVAL

ASSOCIATE ARCHITECTS-

DESIGN ASSOCIATES INC.

A - 163, Sector - 136, Noida - Greater Noida Expressway, Noida - 201301 Email: sachin.agarwal@designassociates.in

MECHANICAL CONSULTANT-ARK CONSULTANT, NEW DELHI

ELECTRICAL CONSULTANT-ARK CONSULTANT, NEW DELHI

PLUMBING CONSULTANT-

ARK CONSULTANT, NEW DELHI STRUCTURE CONSULTANT-

CE CON ENGG. , NEW DELHI PROJECT-


> COMMERCIAL COMPLEX AT POLO MARKET SHILLONG

DRAWING TITLE-


GROUND FLOOR PLAN DB DETAIL LAYOUT

DRAWING PURPOSE-	
FOR TENDER	PURPOSES ONLY

JOB NO	DWG. REF. NO	DATE-
		29-12-2017
SCALE-	REVISION-	DATE OF ISSUE
1:150	R4	04.10.2019
DWG. NO	EL-105	

 

SHEET SIZE-	SHEET NO-
A1	
DRAWN BY-	CHECKED BY-
BUNTY	PANKAJ

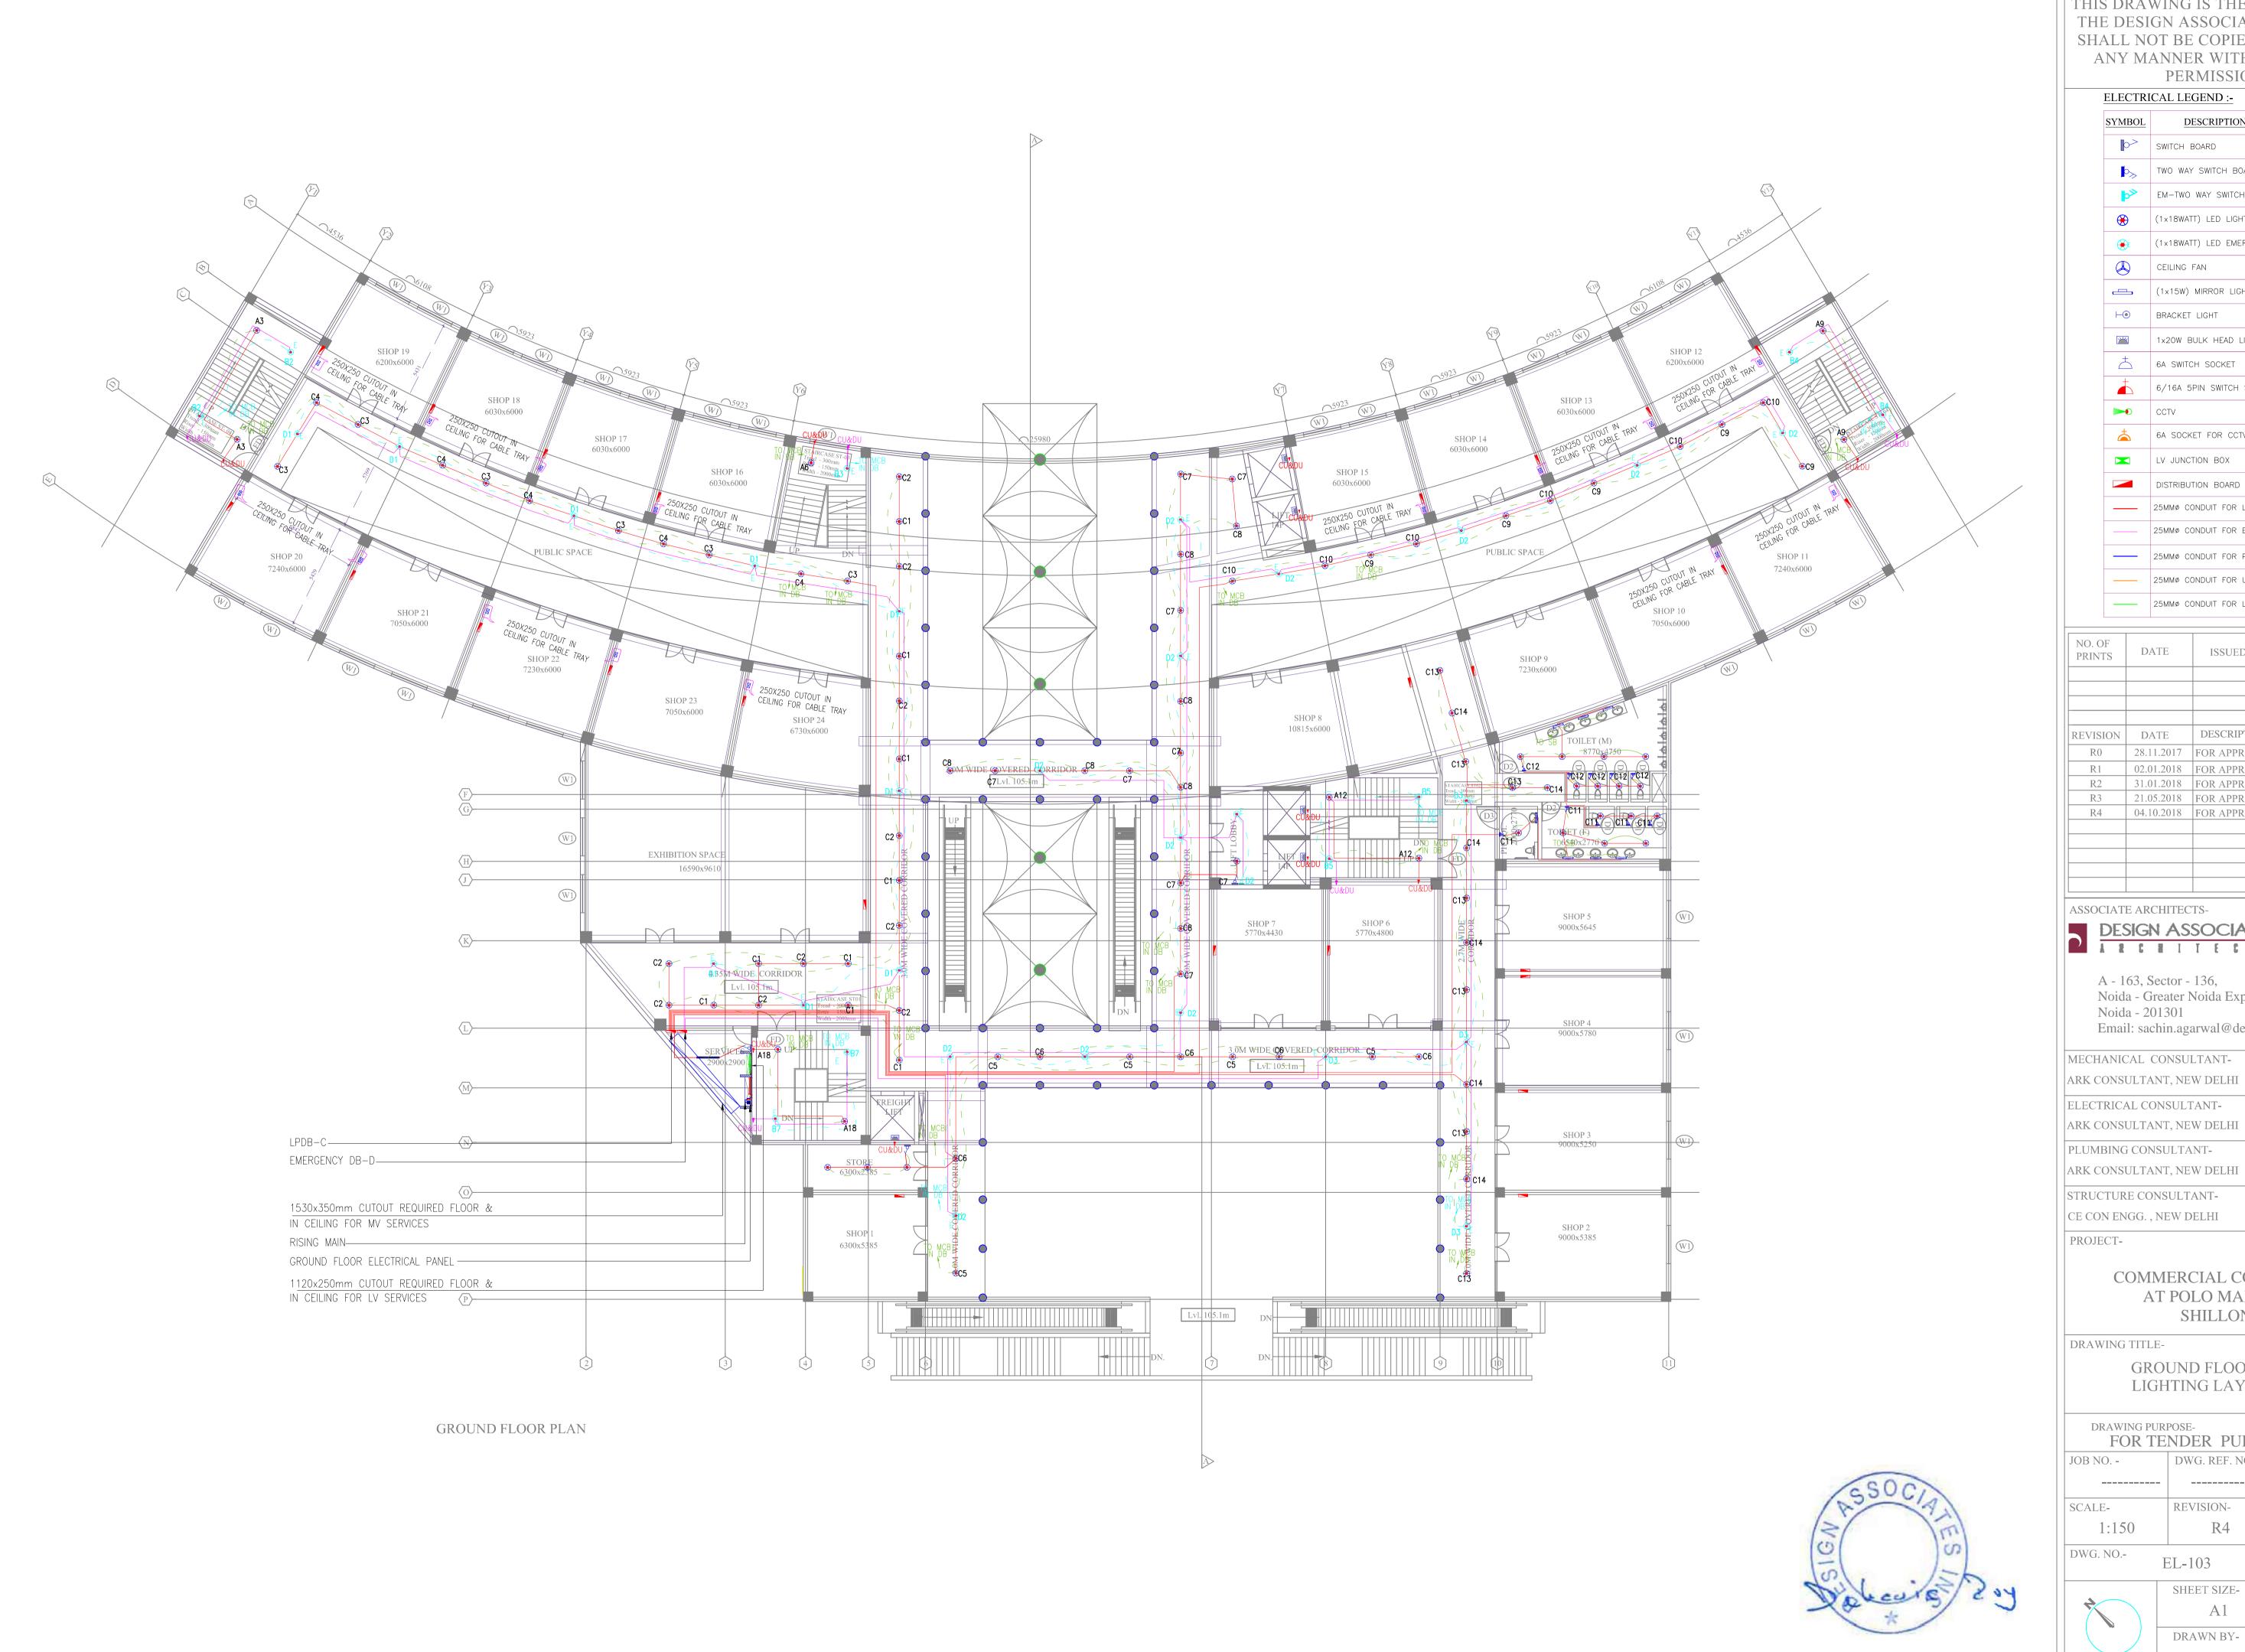

ELECTRICAL LEGEND :-

SYMBOL	DESCRIPTION	
 >	SWITCH BOARD	
 ⊳>	TWO WAY SWITCH BOARD	
b>>	EM-TWO WAY SWITCH BOARD	
€	(1×18WATT) LED LIGHT	
€ E	(1×18WATT) LED EMERGENCY LIGHT	
(4)	CEILING FAN	
	(1×15W) MIRROR LIGHT (LED)	
⊢ ⊚	BRACKET LIGHT	
	1x20W BULK HEAD LIGHT	
\pm	6A SWITCH SOCKET	
	6/16A 5PIN SWITCH SOCKET	
> ••	CCTV	
<u></u>	6A SOCKET FOR CCTV	
	LV JUNCTION BOX	
	DISTRIBUTION BOARD	
	25MMØ CONDUIT FOR LIGHT	
	25MMØ CONDUIT FOR EMERGENCY	
	25MMØ CONDUIT FOR POWER	
	25MMØ CONDUIT FOR UPS	
	25MMØ CONDUIT FOR LV	

NO. OF PRINTS	DATE	ISSUED TO	REMARKS
	D 4 500	DESCRIPTION	BY
REVISION R0	DATE 28.11.2017	DESCRIPTION FOR APPROVAL	NIKHIL TYAC
R1	02.01.2018	FOR APPROVAL	NIKHIL TYAC
R2	31.01.2018	FOR APPROVAL	NIKHIL TYAC
R3	21.05.2018	FOR APPROVAL	NIKHIL TYAC
R4	04.10.2018	FOR APPROVAL	BUNTY

DESIGN ASSOCIATES INC.

Noida - Greater Noida Expressway, Noida - 201301 Email: sachin.agarwal@designassociates.in

ARK CONSULTANT, NEW DELHI

CE CON ENGG., NEW DELHI


COMMERCIAL COMPLEX AT POLO MARKET SHILLONG

GROUND FLOOR PLAN LIGHTING LAYOUT


DRAWING PURPOSE-

	FOR TENDER PURPOSES ONLY		
	JOB NO DWG. REF. NO DATE-		
			29-12-2017
	SCALE-	REVISION-	DATE OF ISSUE-
	1:150	R4	04.10.2019
- 1			

 EL-103



SHEET SIZE-	SHEET NO-
A1	
DRAWN BY-	CHECKED BY-
BUNTY	PANKAJ

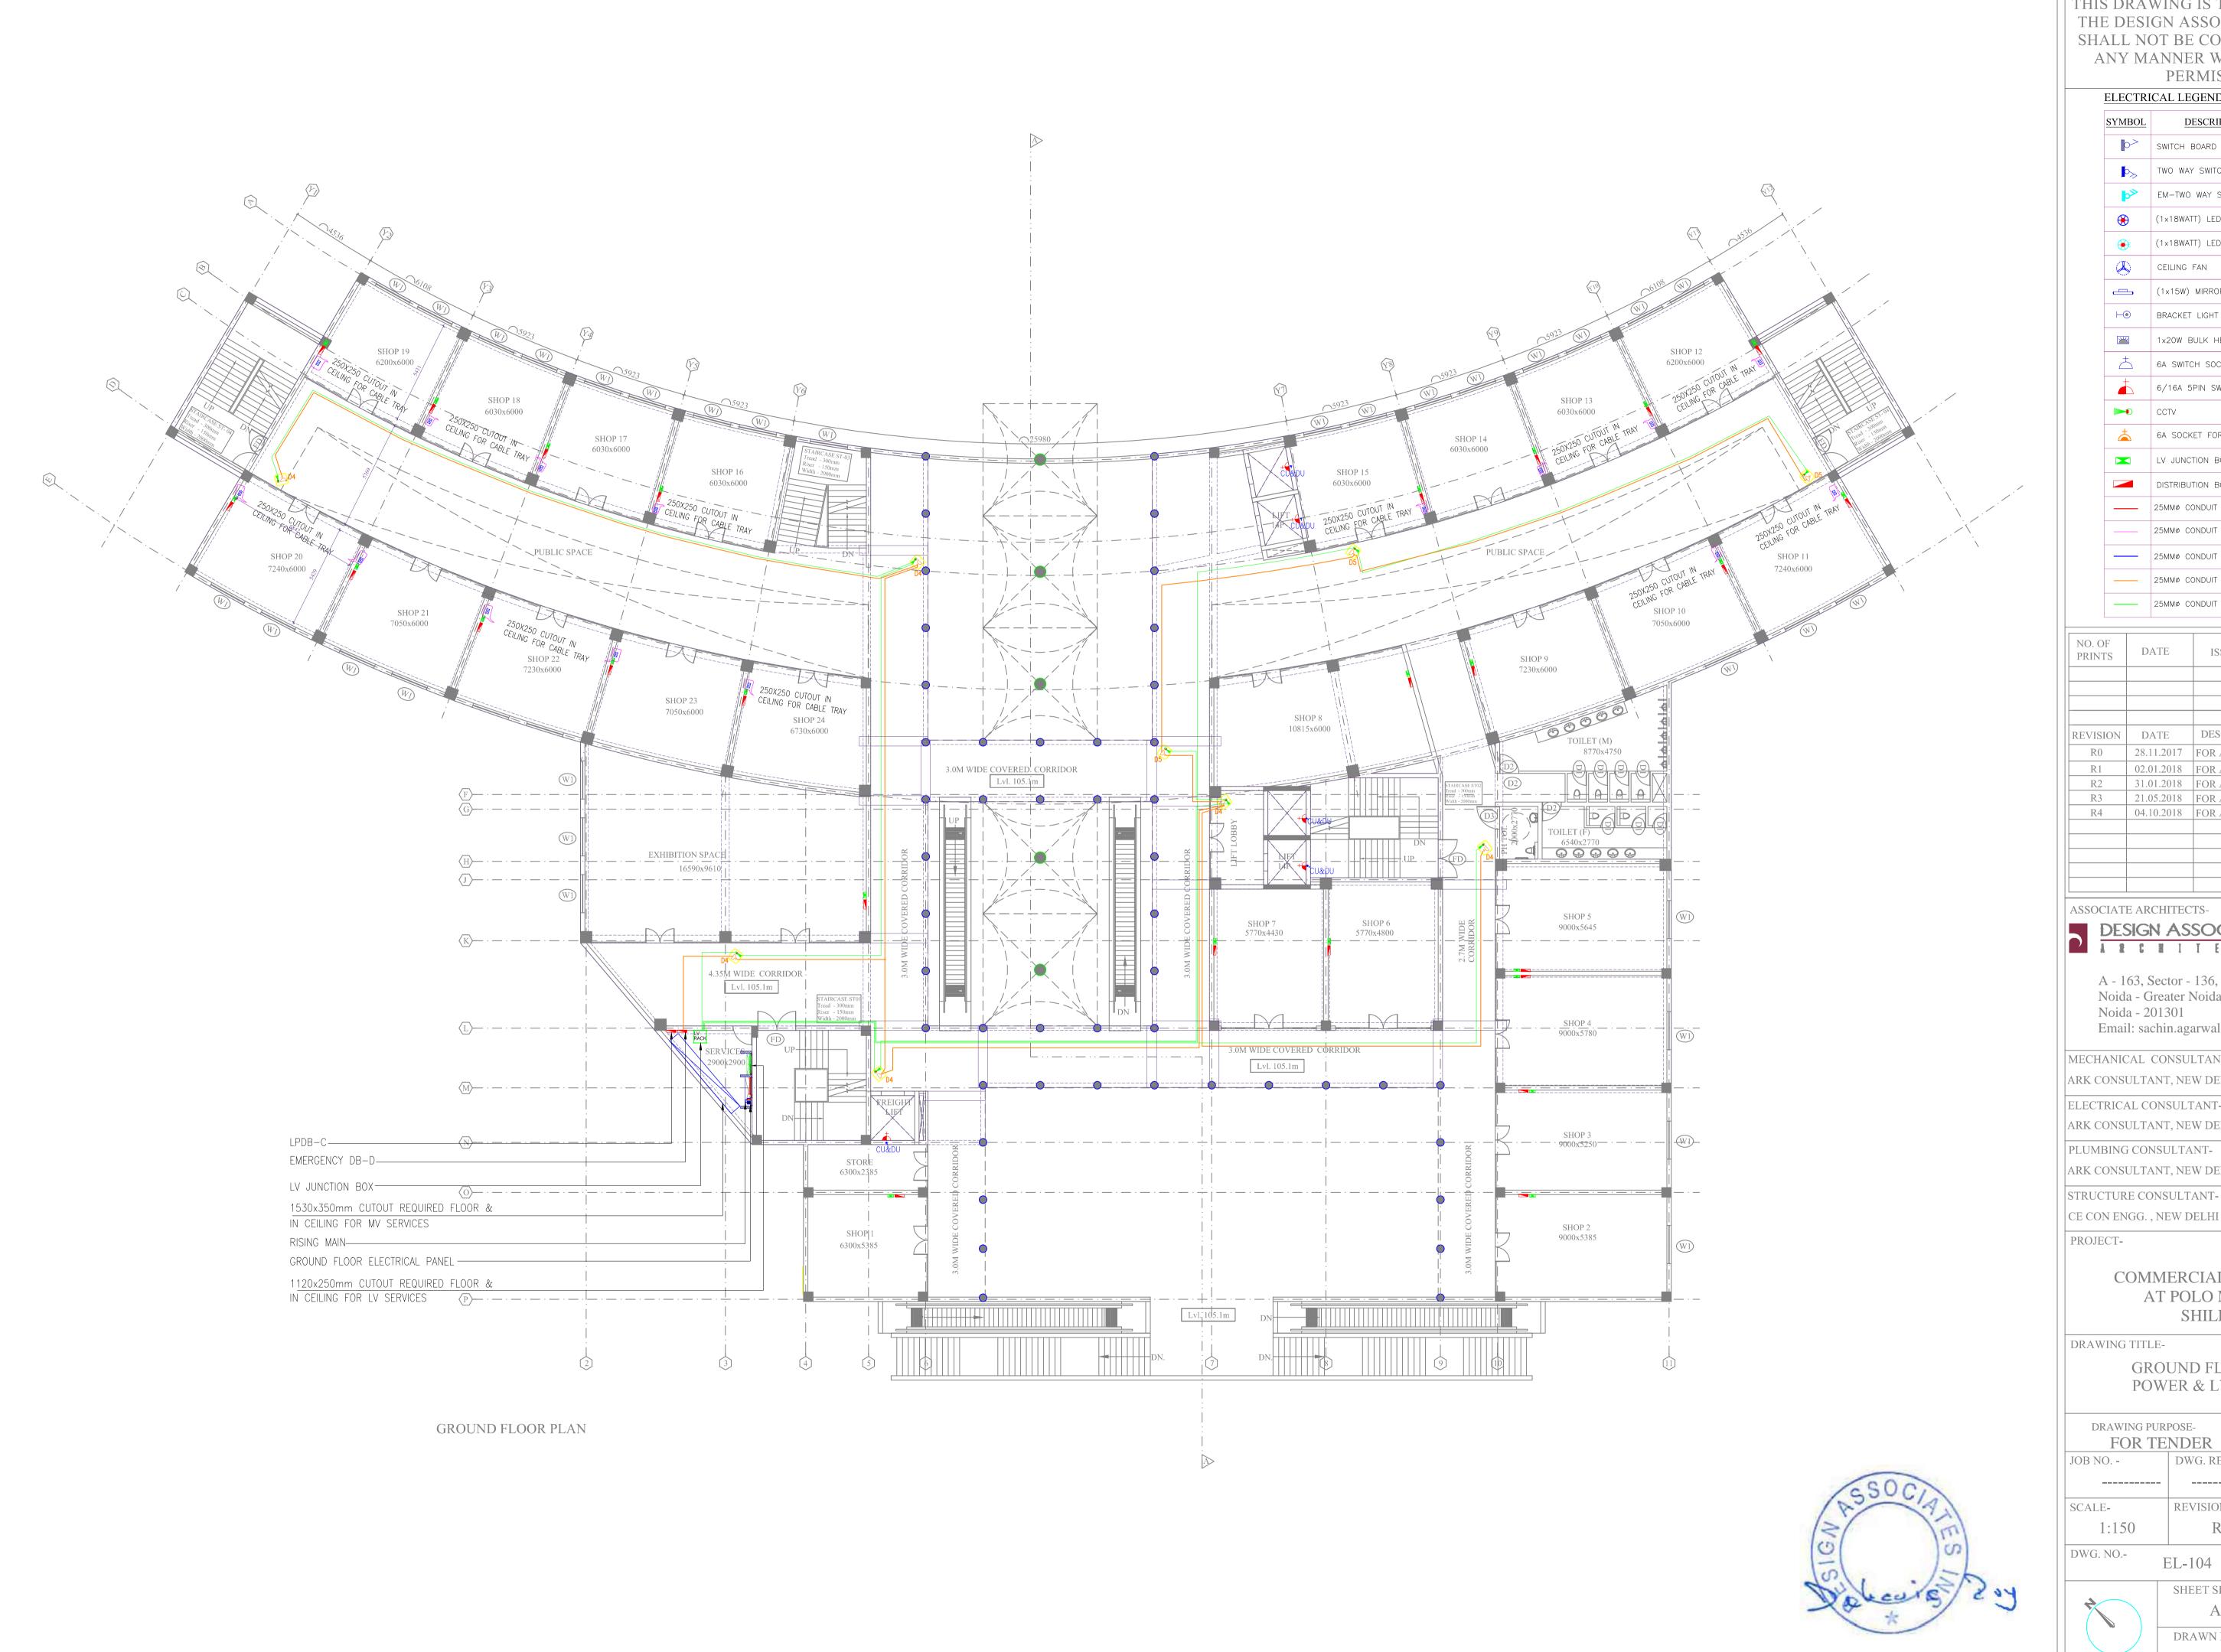

ELECTRICAL LEGEND :-

SYMBOL	DESCRIPTION
 >	SWITCH BOARD
Þ»	TWO WAY SWITCH BOARD
þ»	EM-TWO WAY SWITCH BOARD
€	(1×18WATT) LED LIGHT
*	(1x18WATT) LED EMERGENCY LIGHT
(4)	CEILING FAN
	(1x15W) MIRROR LIGHT (LED)
⊢ ⊚	BRACKET LIGHT
	1x20W BULK HEAD LIGHT
$\stackrel{+}{\triangle}$	6A SWITCH SOCKET
<u></u>	6/16A 5PIN SWITCH SOCKET
> ••	CCTV
<u></u>	6A SOCKET FOR CCTV
	LV JUNCTION BOX
	DISTRIBUTION BOARD
	25MMØ CONDUIT FOR LIGHT
	25MMØ CONDUIT FOR EMERGENCY
	25MMØ CONDUIT FOR POWER
	25MMØ CONDUIT FOR UPS
	25MMØ CONDUIT FOR LV

NO. OF PRINTS	DATE	ISSUED TO	REMARKS
REVISION	DATE	DESCRIPTION	BY
R0	28.11.2017	FOR APPROVAL	NIKHIL TYAG
R1	02.01.2018	FOR APPROVAL	NIKHIL TYAG
R2	31.01.2018	FOR APPROVAL	NIKHIL TYAG
R3	21.05.2018	FOR APPROVAL	NIKHIL TYAG
R4	04.10.2018	FOR APPROVAL	BUNTY

ASSOCIATE ARCHITECTS-

DESIGN ASSOCIATES INC.

A - 163, Sector - 136, Noida - Greater Noida Expressway, Noida - 201301 Email: sachin.agarwal@designassociates.in

MECHANICAL CONSULTANT-

ARK CONSULTANT, NEW DELHI

ELECTRICAL CONSULTANT-ARK CONSULTANT, NEW DELHI

ARK CONSULTANT, NEW DELHI

STRUCTURE CONSULTANT-

CE CON ENGG., NEW DELHI

COMMERCIAL COMPLEX AT POLO MARKET SHILLONG

DRAWING TITLE-

GROUND FLOOR PLAN POWER & LV & UPS LAYOUT

DRAWING PURPOSE-

	FOR TENDER PURPOSES ONLY			
	JOB NO DWG. REF. NO		DATE-	
	SCALE- REVISION-		DATE OF ISSUE-	
	1:150	R4	04.10.2019	
DWG. NO EL-104				



SHEET SIZE-	SHEET NO-
A1	
DRAWN BY-	CHECKED BY-
BUNTY	PANKAJ